

# SITE PLAN SCALE 1:200 @ A1

### LINE TYPES

EXISTING SERVICES

ESD	EXISTING SEWAGE DRAIN
EWS	EXISTING WATER MAIN
	PROPOSED SERVICES
	STORMWATER PIPE
	SEWAGE DRAIN, WASTE PIPE
	COLD WATER SERVICE
	HOT WATER SERVICE
	VENTILATION PIPING
	HVAC CONDENSATE DRAINAGE

VERTICAL DROP / RISE (ALL SERVICES)

### SYMBOLS

SANITARY PLUMBING

FWG �	FLOOR WASTE GULLY TRAP
DT 🛞	DISCONNECTOR GULLY
IWSP (*)	INDUSTRIAL WASTE SAMPLING POINT
ORG 🛞	OVERFLOW RELIEF GULLY
AAV �	AIR ADMITTANCE VALVE
40 👣	FIXTURE TRAP (ABOVE FLOOR) SIZE VARIES
co Ø	CLEAN OUT
IOS Ø	INSPECTION OPENING TO SURFACE
AP <	ALTERING PIPE
TD 🐠	TUNDISH

## SYMBOLS Cont.

WATER SUPPLY

ISOLATION BALL VALVE

DCV	KM	DOUBLE CHECK VALVE
RPZD	М	REDUCED PRESSURE ZONE DEVICE
TMV	<b>d</b>	THERMOSTATIC MIXING VALVE
	<b>\$</b>	FIXTURE TAP - HOT, COLD, MIXER
НС	<b>\$</b>	HOSE COCK WITH ANTI SIPHON VACUUM BREAKER
GV	<b>100</b> 1	ISOLATION GATE VALVE
		STORMWATER DRAINAGE
		STORWWATER DRAINAGE
RWP	•	RAINWATER PIPE
SUMF		BOX GUTTER SUMP (BY ROOFER)
AP	<b>&lt;</b>	ALTERING PIPE
FBSB		GALVINS FLAT BACK SUMP BOX C/W IRON GRATE MODEL 230519.

## **ABBREVIATIONS**

ALL SERVICES (ALPHABETICAL ORDER)

AAV	AIR ADMITTANCE VALVE
AFFL	ABOVE FINISHED FLOOR LEVEL
BV	BALL VALVE
CI	CAST IRON
CO	CLEAN OUT POINT
C/W	COMPLETE WITH
CWR	COLD WATER RISER
DG	DISCONNECTOR GULLY WITH MOUND & GRATE
RWP	STORMWATER DOWNPIPE
DV	DRAINAGE VENT

## ABBREVIATIONS Cont.

ALL SERVICES (ALPHABETICAL ORDER)

W	FLOOR WASTE
WG	FLOOR WASTE GULLY WITH CHROME PLATED GRATE
GV	GATE VALVE
HC	HOSE COCK WITH ANTI SIPHON VACUUM BREAKER
WU	HOT WATER UNIT
L.	INVERT LEVEL
L. 10	INVERT LEVEL INSPECTION OPENING

POLYVINYL CHLORIDE

#### NOTES

The Hydraulic Services Sub-Contractor is to verify all dimensions on site before commencing work. Do not scale this drawing.

This drawing is to be read in conjunction with the contract specification in the interpretation of this drawing. The specification text has precedence over all of the illustrations on this drawing.

The following take precedence over the service requirements shown on this drawing and the contract specification:

• Legislative Federal, State and Local Authority Requirements.

Contractual Relationships

Responsibilities and duties of the principal, contractor and the superintendent as defined in the Contract are not altered by this drawing.

ISSUE	DATE	DESCRIPTION	AP
Α	16.06.21	PRELIMINARY ISSUE	AE
В	29.06.21	CDC ISSUE	Al

# CONSULTANT



Hydraulic Electrical Mechanical Structural
E: info@hemsconsult.com.au
PO Box 381 Subiaco WA 6904

| ARCHITECT

#### D'AGOSTINO + LUFF ARCHITECTS

Unit 4 / 71 Kent Strret Busselton WA 6280

PROJECT

#### COMMERCIAL DEVELOPMENT LOT 69 (HN23) Antlia Way


LOT 69 (HN23) Antlia Way Australind WA

TITLE

HYDRAULIC SERVICES 1:200 SCALE SITE PLAN LEGEND & NOTES

21.009	H00	В
PROJECT #	DRAWING #	REVISION
1:200 @ A1	AB	MM
SCALE	DESIGN	CHECKED

This drawing is the property of HEMS Consulting Pty Ltd. Copyright © remains vested in HEMS Consulting Pty Ltd.

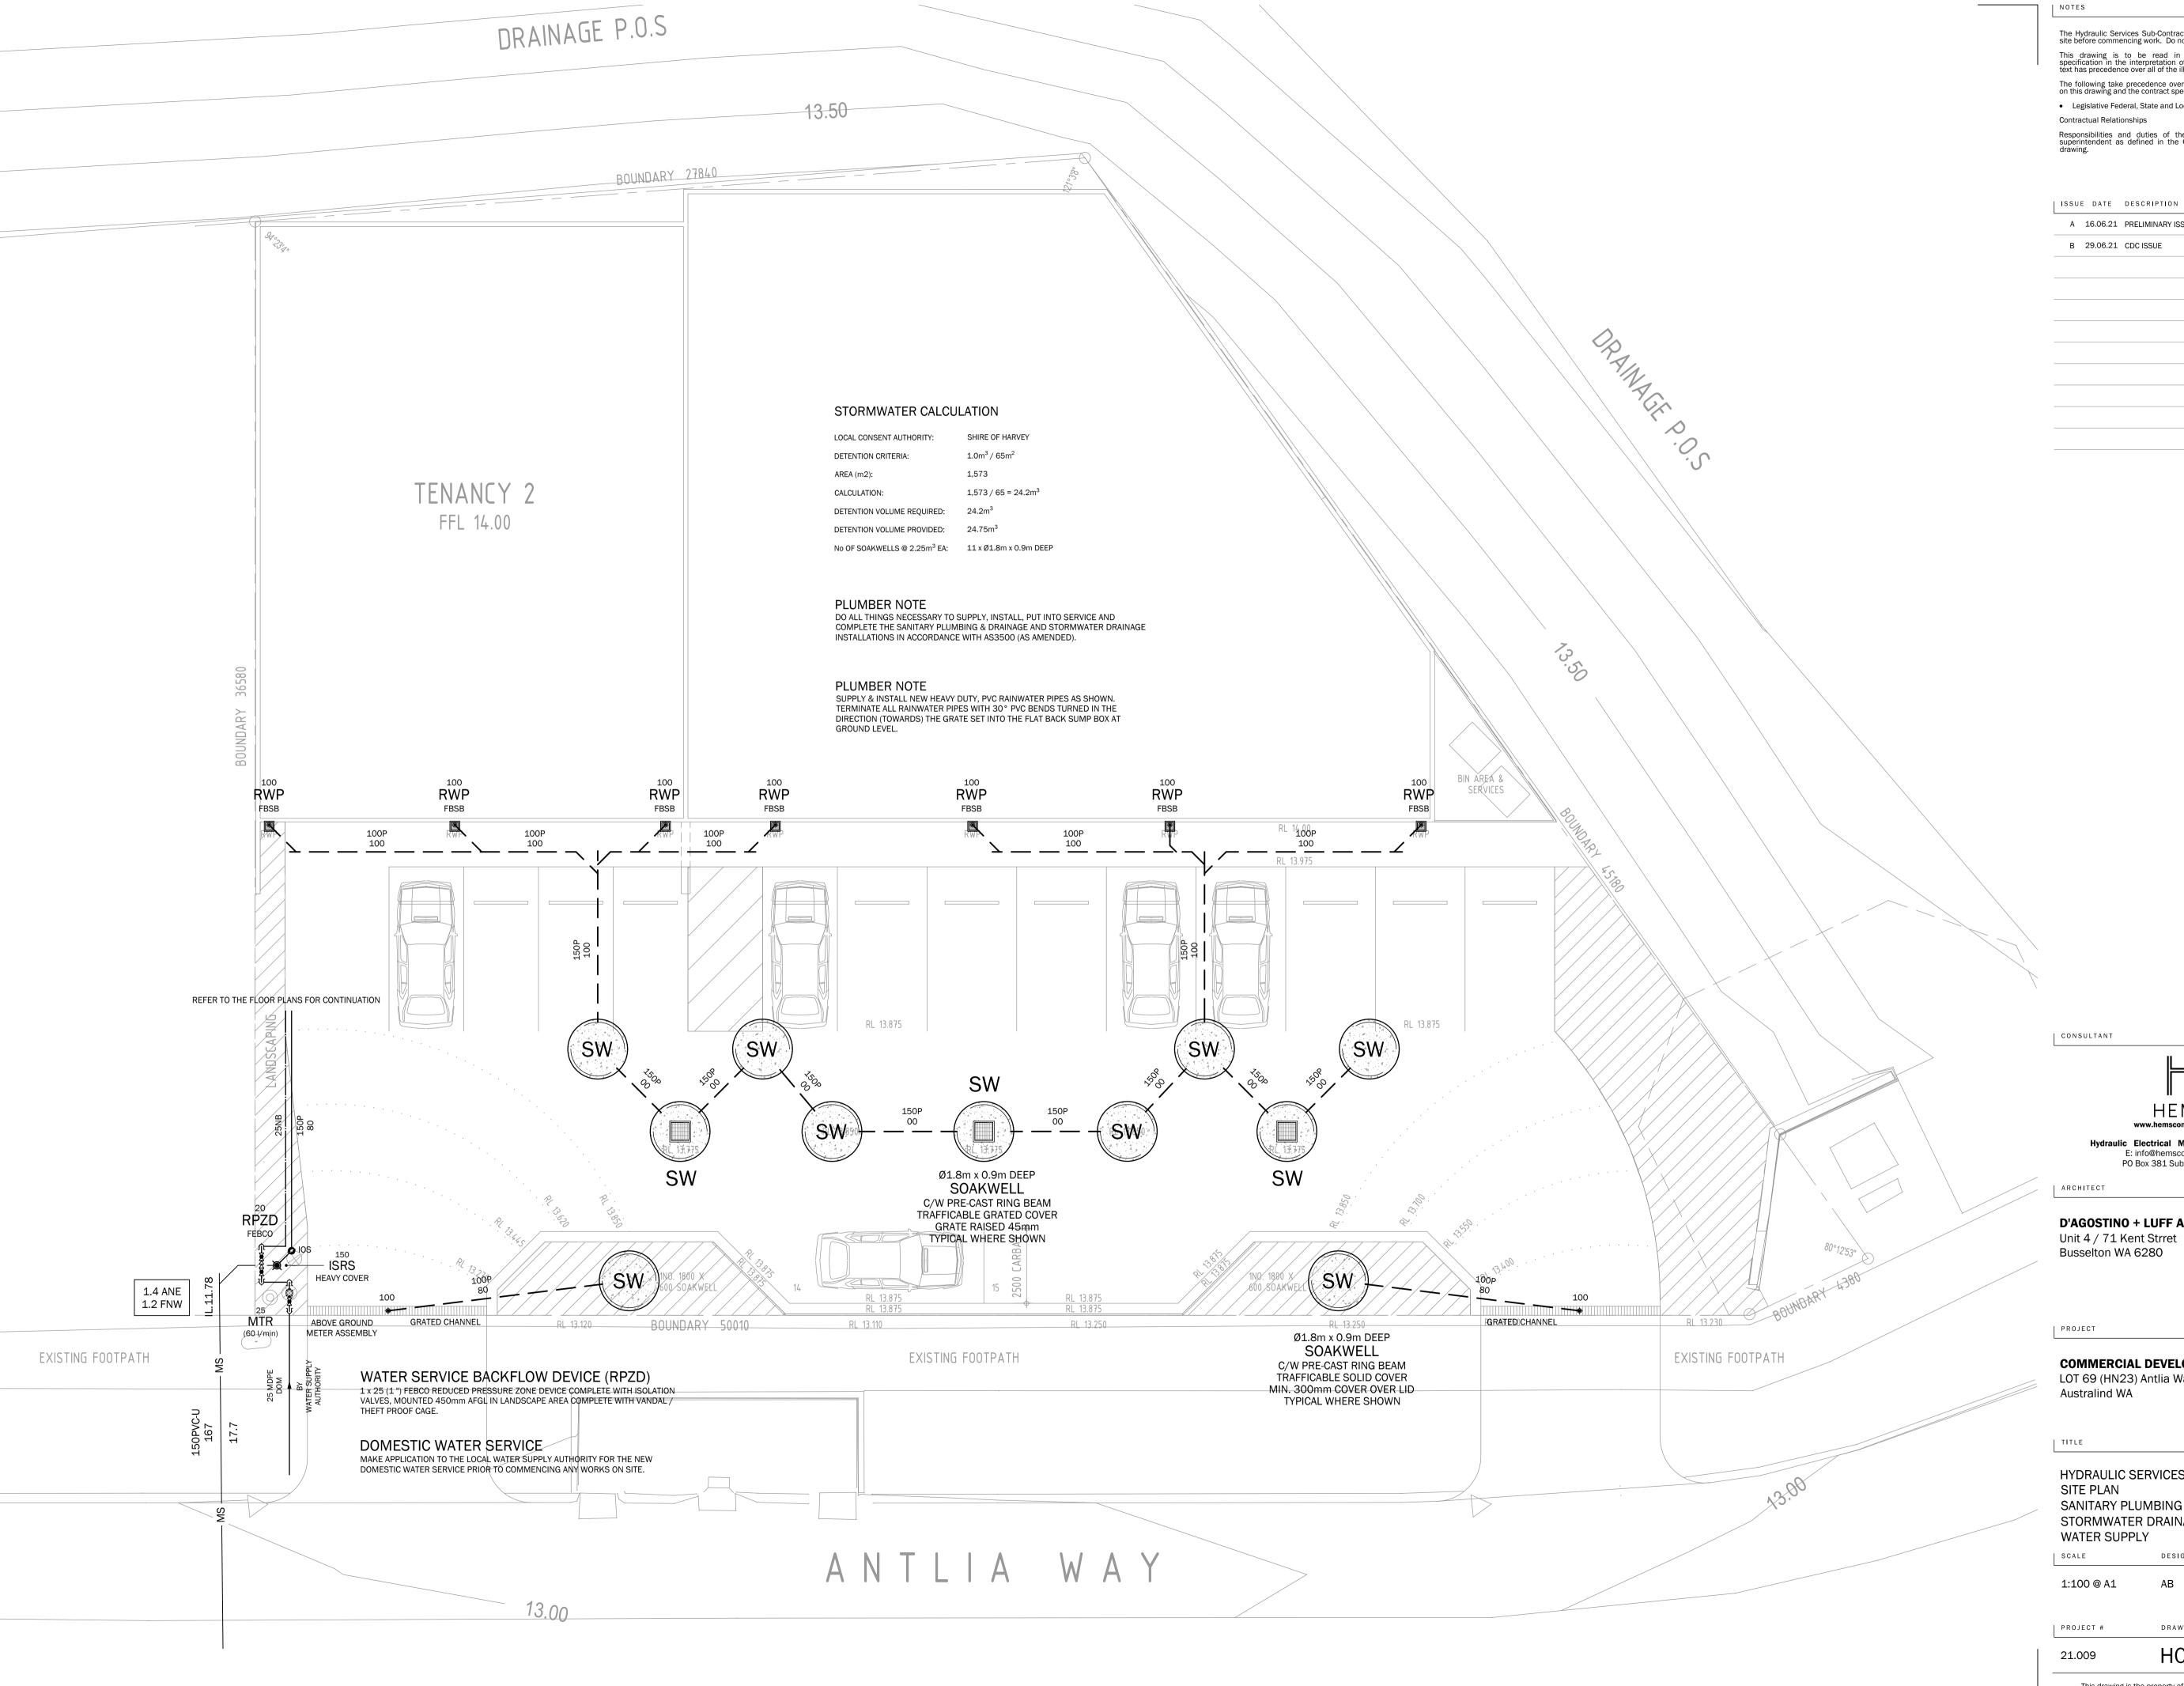

The Hydraulic Services Sub-Contractor is to verify all dimensions on site before commencing work. Do not scale this drawing. This drawing is to be read in conjunction with the contract specification in the interpretation of this drawing. The specification text has precedence over all of the illustrations on this drawing. The following take precedence over the service requirements shown on this drawing and the contract specification: Legislative Federal, State and Local Authority Requirements.

Contractual Relationships Responsibilities and duties of the principal, contractor and the superintendent as defined in the Contract are not altered by this drawing.

A 16.06.21 PRELIMINARY ISSUE  B 29.06.21 CDC ISSUE		
B 29.06.21 CDC ISSUE	B 29.06.21 CDC ISSUE	



Hydraulic Electrical Mechanical Structural E: info@hemsconsult.com.au PO Box 381 Subiaco WA 6904

#### D'AGOSTINO + LUFF ARCHITECTS

Busselton WA 6280


#### COMMERCIAL DEVELOPMENT LOT 69 (HN23) Antlia Way

HYDRAULIC SERVICES SITE PLAN SANITARY PLUMBING & DRAINAGE STORMWATER DRAINAGE & DISPOSAL

SCALE	DESIGN	CHECKED
1:100 @ A1	АВ	ММ

DRAWING # REVISION

This drawing is the property of HEMS Consulting Pty Ltd. Copyright © remains vested in HEMS Consulting Pty Ltd.

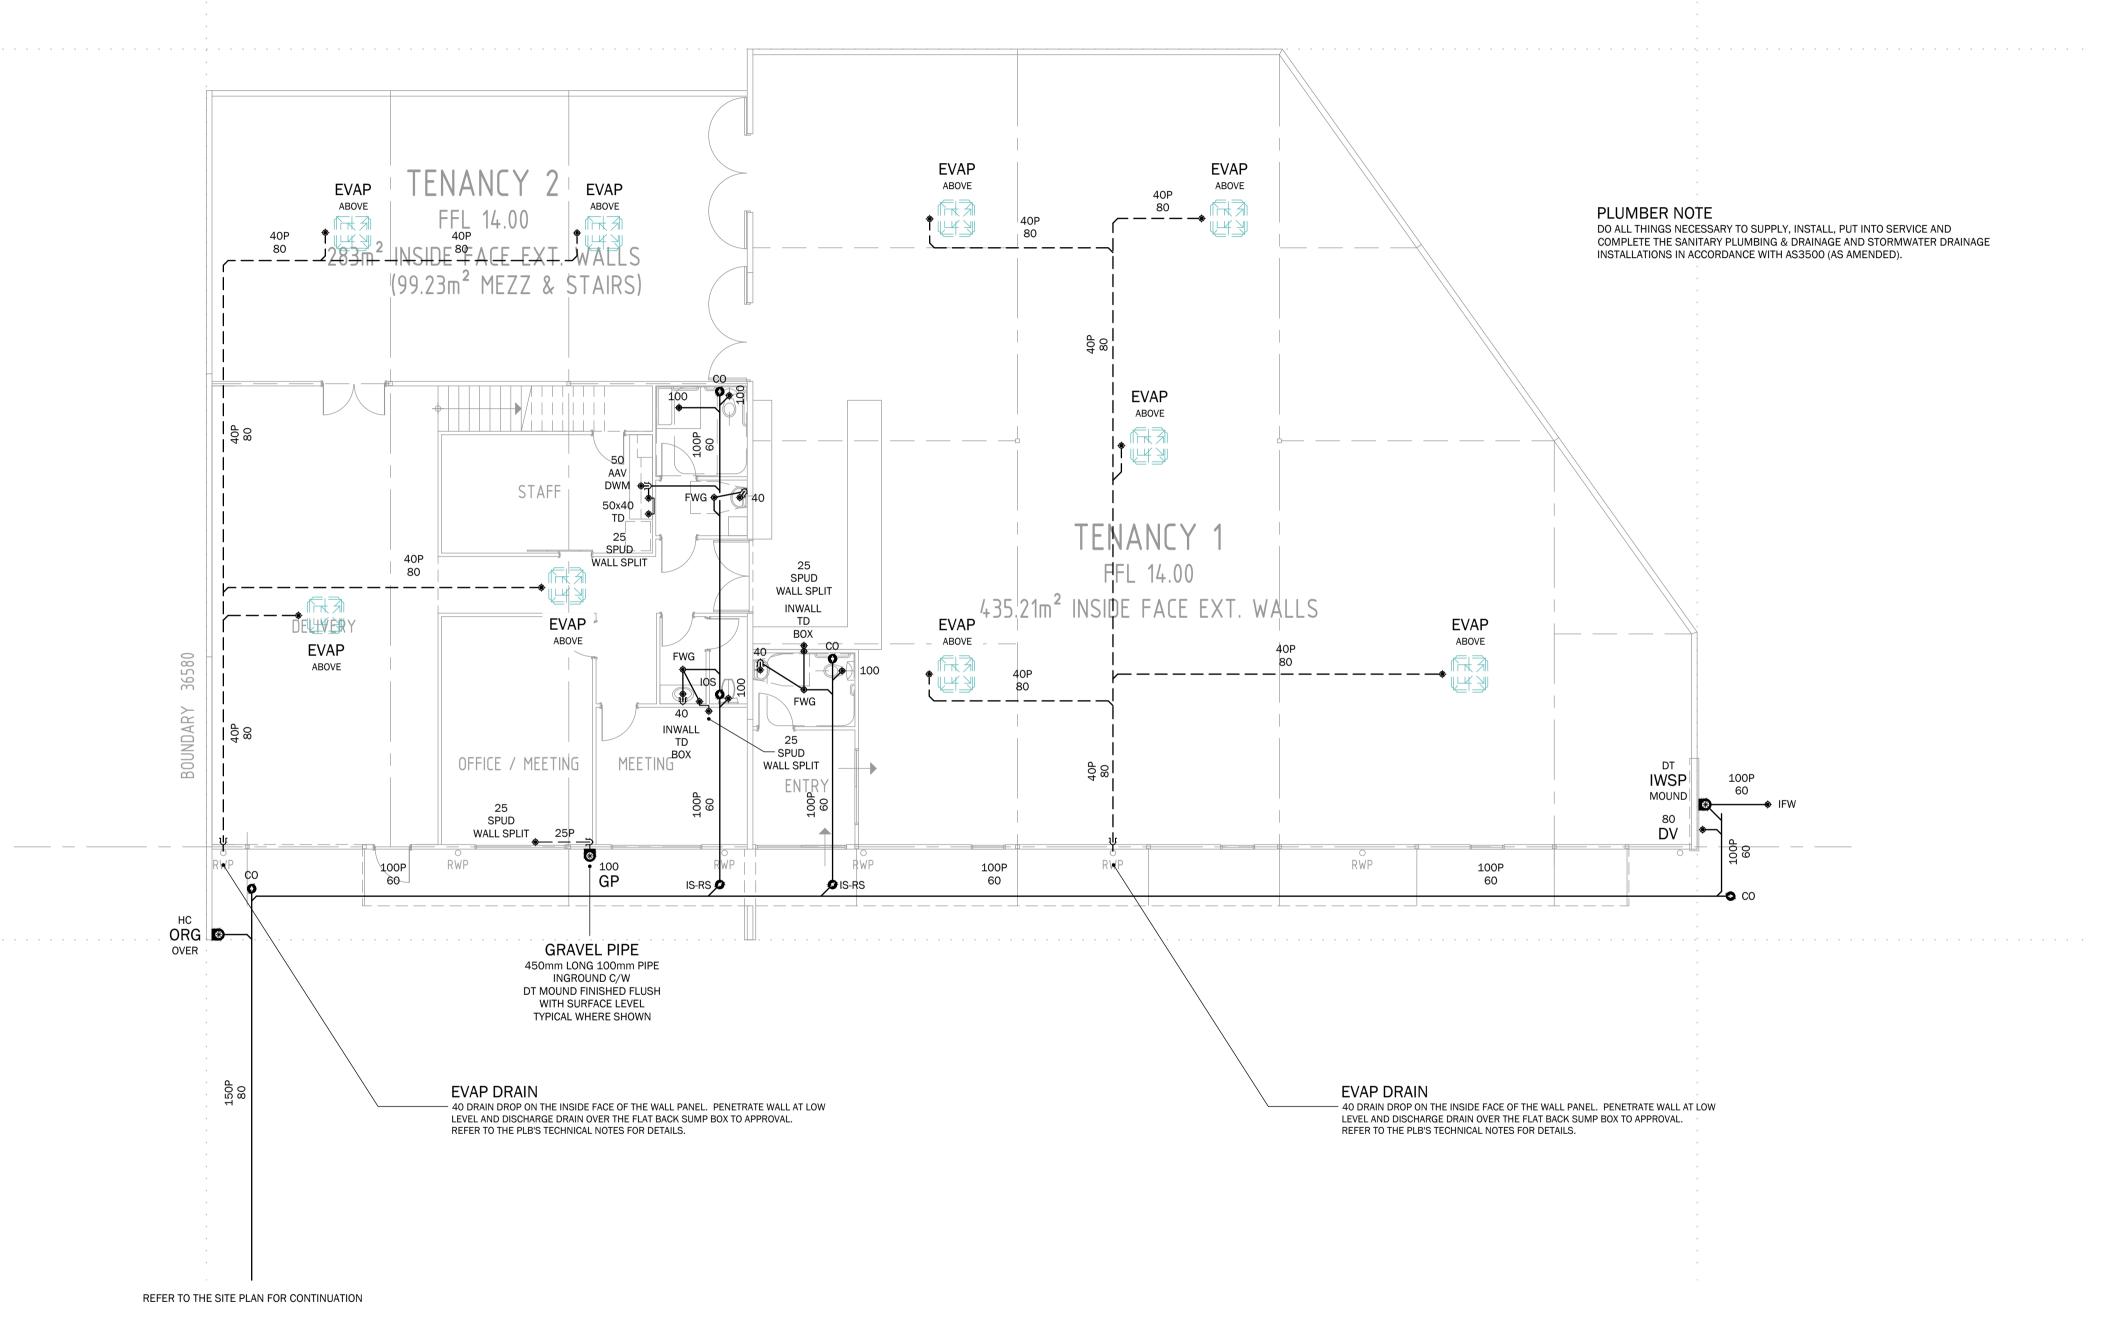

| NOTES

The Hydraulic Services Sub-Contractor is to verify all dimensions on site before commencing work. Do not scale this drawing.

This drawing is to be read in conjunction with the contract specification in the interpretation of this drawing. The specification text has precedence over all of the illustrations on this drawing.

The following take precedence over the service requirements shown on this drawing and the contract specification:

Legislative Federal, State and Local Authority Requirements.

Contractual Relationships

Responsibilities and duties of the principal, contractor and the superintendent as defined in the Contract are not altered by this drawing.

A 16.06.21 PRELIMINARY ISSUE AB
B 29.06.21 CDC ISSUE AB

CONSULTANT



Hydraulic Electrical Mechanical Structural
E: info@hemsconsult.com.au
PO Box 381 Subiaco WA 6904

ARCHITECT

D'AGOSTINO + LUFF ARCHITECTS

Unit 4 / 71 Kent Strret Busselton WA 6280

PROJECT

COMMERCIAL DEVELOPMENT LOT 69 (HN23) Antlia Way Australind WA

| 1


HYDRAULIC SERVICES FLOOR PLAN SANITARY PLUMBING & DRAINAGE

1:100 @ A1 AB MM

PROJECT # DRAWING # REVISION

421.009 HO2 B

This drawing is the property of HEMS Consulting Pty Ltd. Copyright © remains vested in HEMS Consulting Pty Ltd.

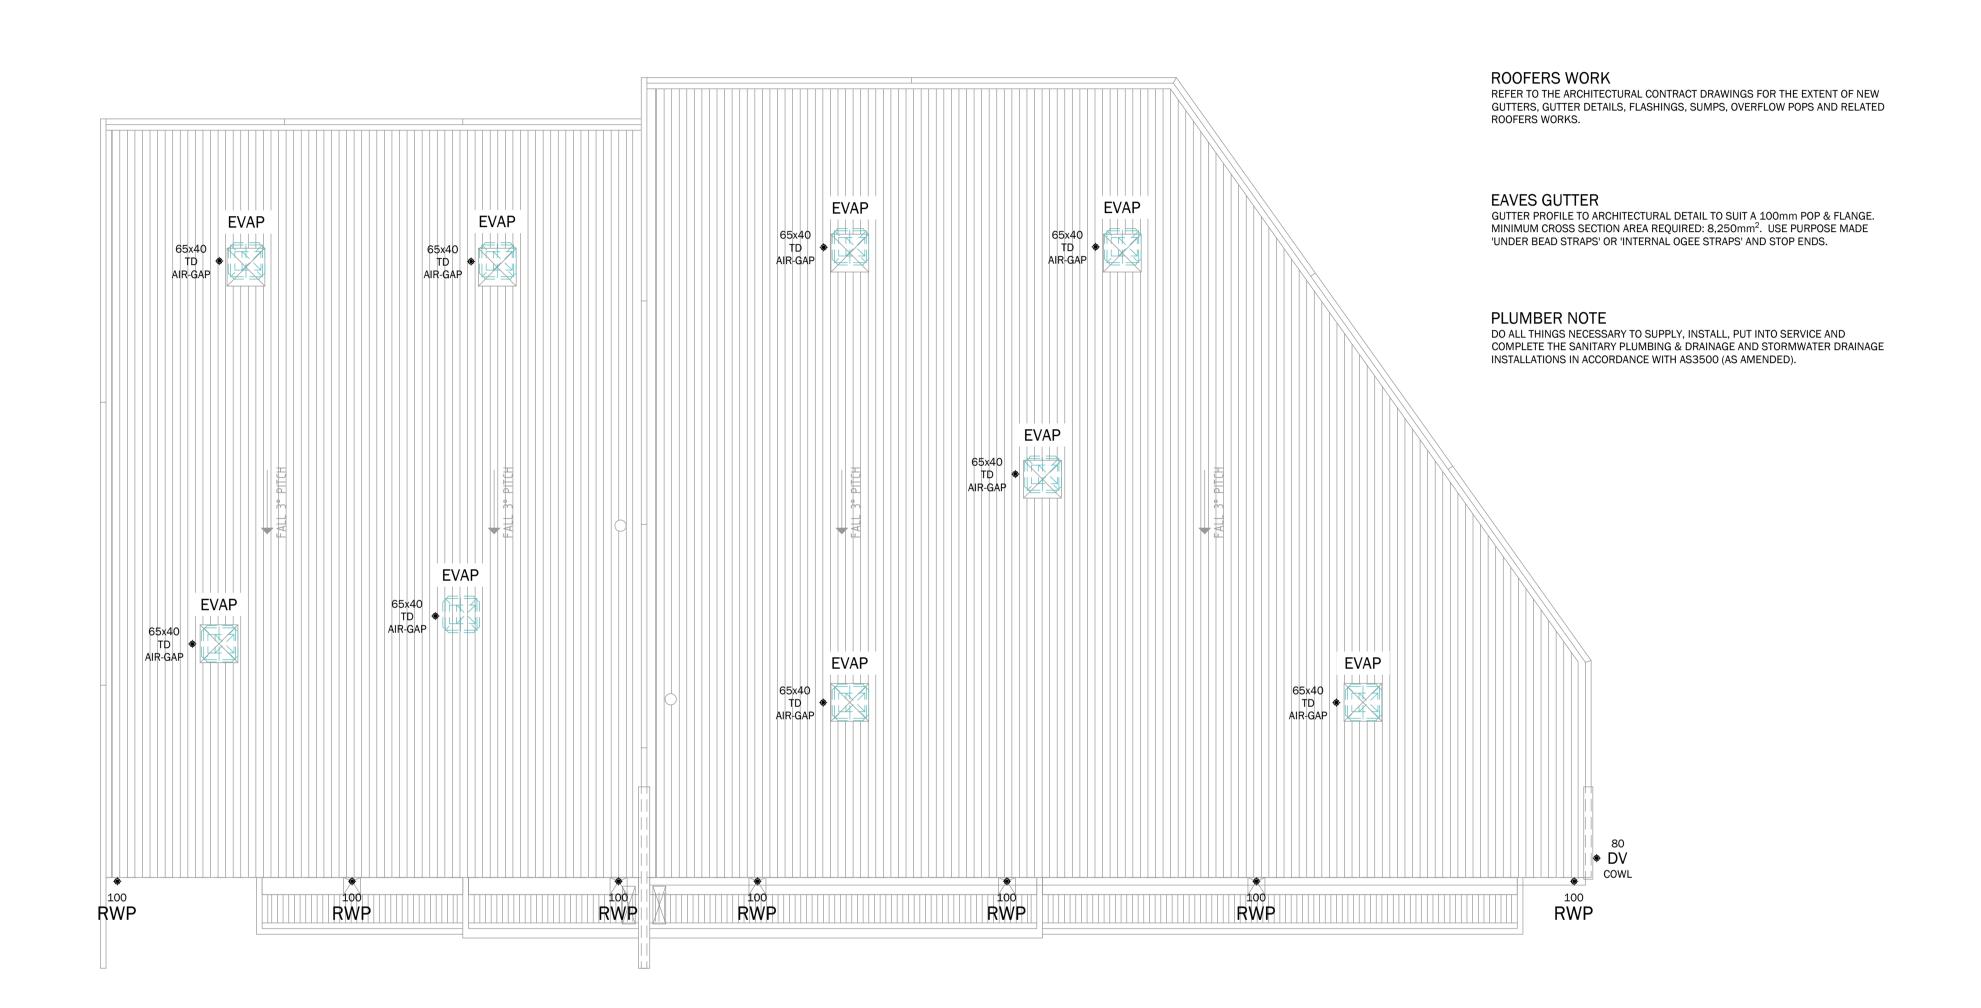

NOTES

The Hydraulic Services Sub-Contractor is to verify all dimensions on site before commencing work. Do not scale this drawing.

This drawing is to be read in conjunction with the contract specification in the interpretation of this drawing. The specification text has precedence over all of the illustrations on this drawing.

The following take precedence over the service requirements shown on this drawing and the contract specification:

• Legislative Federal, State and Local Authority Requirements.

Contractual Relationships

Responsibilities and duties of the principal, contractor and the superintendent as defined in the Contract are not altered by this drawing.

Α	16.06.21	PRELIMINARY ISSUE	AB
В	29.06.21	CDC ISSUE	AB

ISSUE DATE DESCRIPTION

CONSULTANT



Hydraulic Electrical Mechanical Structural
E: info@hemsconsult.com.au
PO Box 381 Subiaco WA 6904

ARCHITECT

D'AGOSTINO + LUFF ARCHITECTS

Unit 4 / 71 Kent Strret Busselton WA 6280

PROJECT

COMMERCIAL DEVELOPMENT LOT 69 (HN23) Antlia Way Australind WA

TITLE

SCALE

HYDRAULIC SERVICES ROOF PLAN SANITARY PLUMBING & DRAINAGE STORMWATER DRAINAGE

1:100 @ A1 AB MM


PROJECT # DRAWING # REVISION

21.009 HO3 B

DESIGN

CHECKED

This drawing is the property of HEMS Consulting Pty Ltd. Copyright © remains vested in HEMS Consulting Pty Ltd.

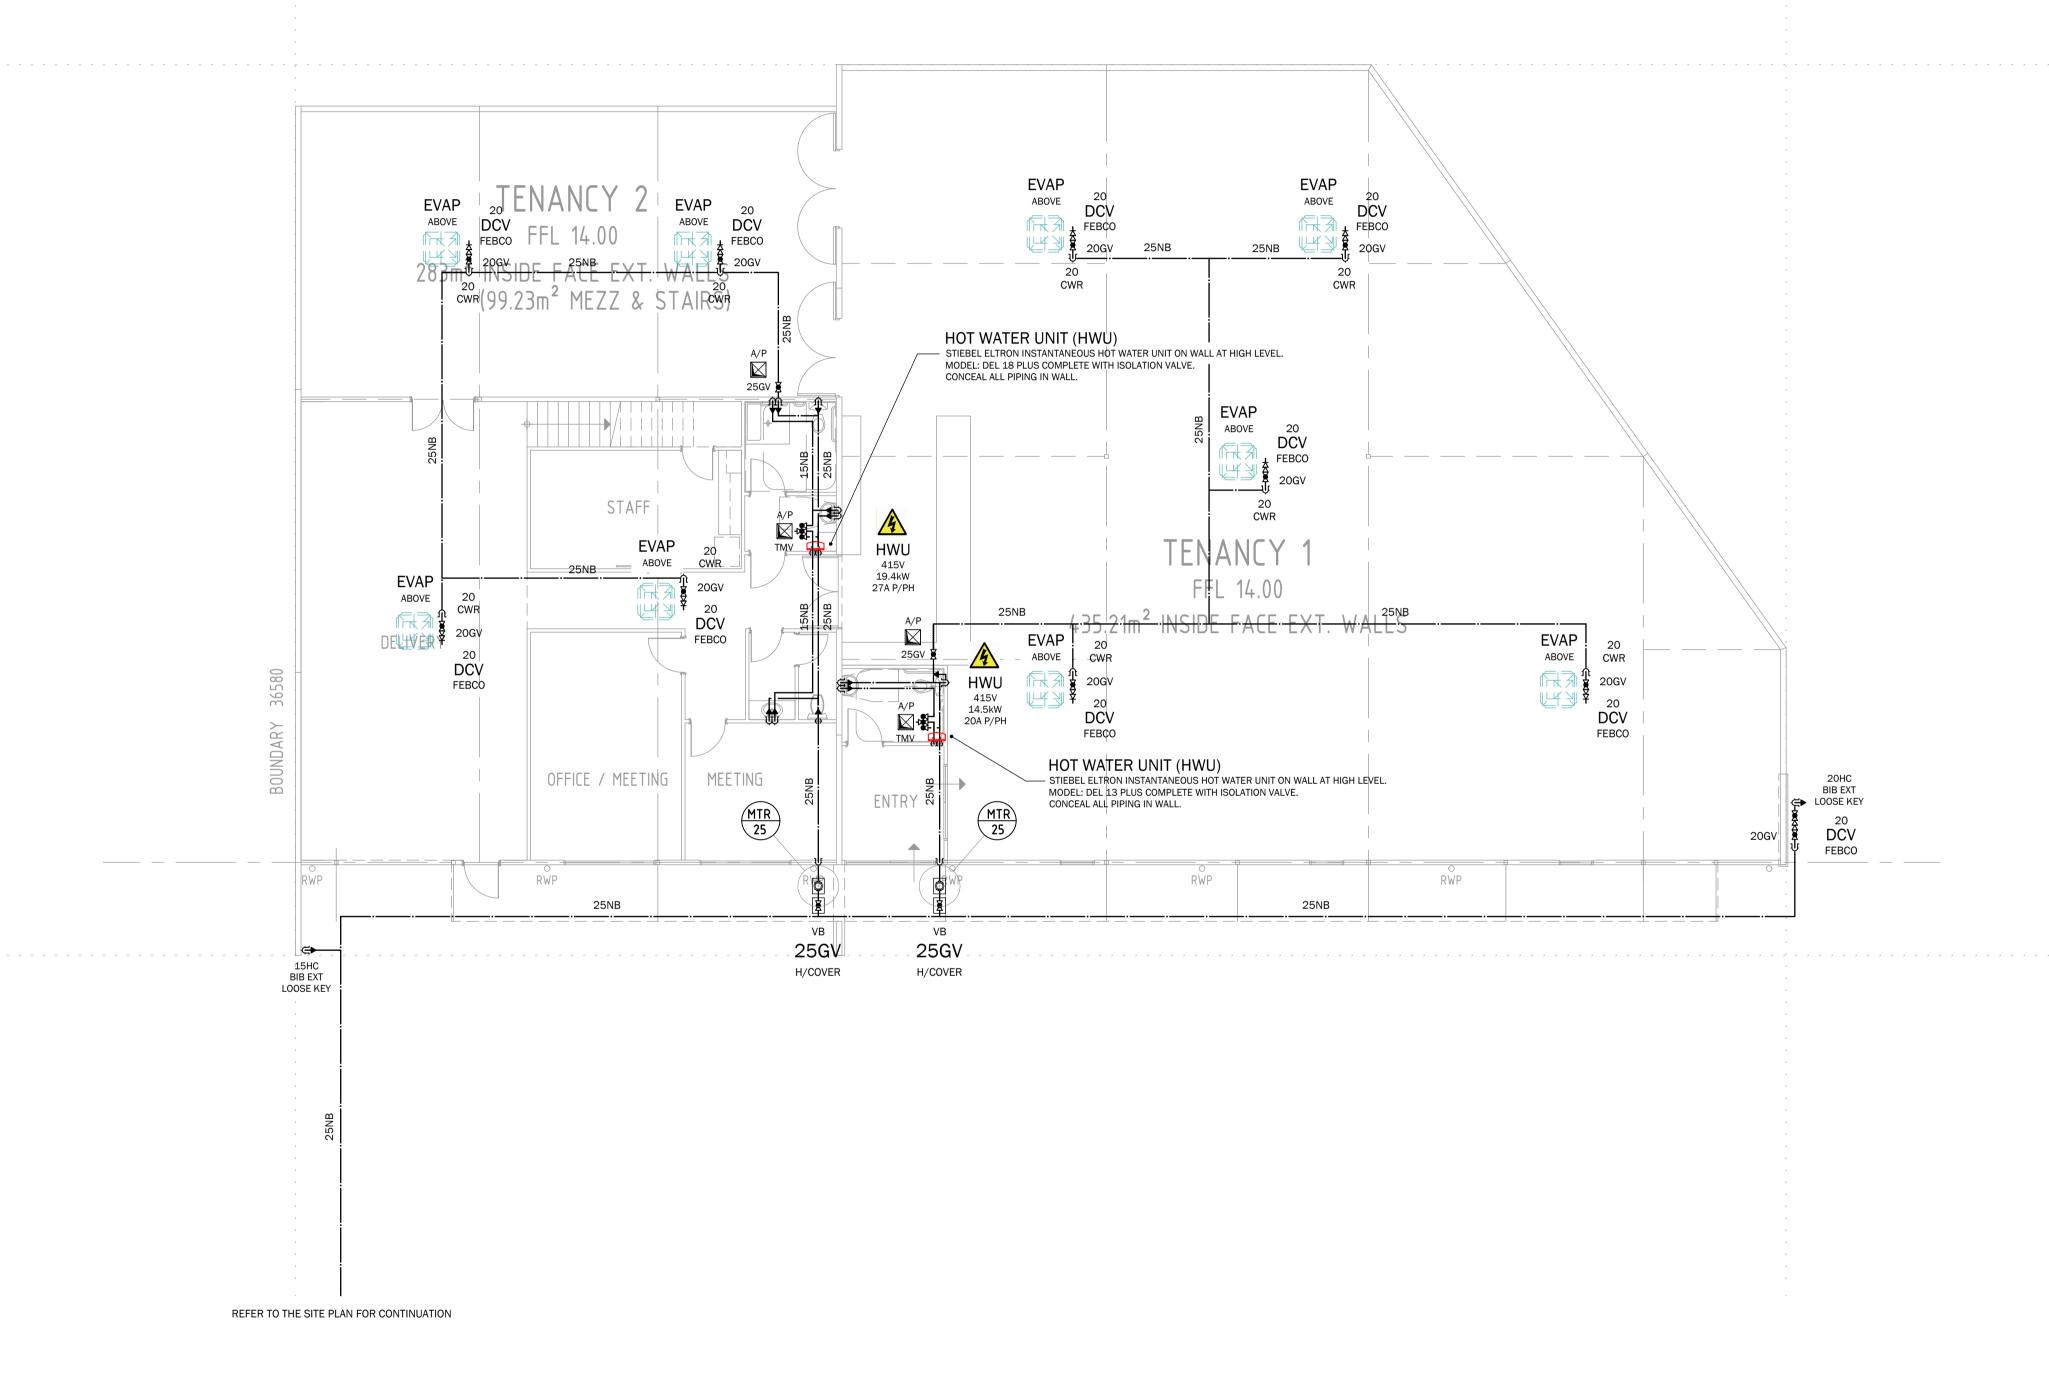

| NOTES

The Hydraulic Services Sub-Contractor is to verify all dimensions on site before commencing work. Do not scale this drawing.

This drawing is to be read in conjunction with the contract specification in the interpretation of this drawing. The specification text has precedence over all of the illustrations on this drawing.

The following take precedence over the service requirements shown on this drawing and the contract specification:

Legislative Federal, State and Local Authority Requirements.

Contractual Relationships

Responsibilities and duties of the principal, contractor and the superintendent as defined in the Contract are not altered by this drawing.

ISSU	E DATE	DESCRIPTION	APP
Α	16.06.21	PRELIMINARY ISSUE	AB
В	29.06.21	CDC ISSUE	AB

CONSULTANT



Hydraulic Electrical Mechanical Structural
E: info@hemsconsult.com.au
PO Box 381 Subiaco WA 6904

ARCHITECT

D'AGOSTINO + LUFF ARCHITECTS

Unit 4 / 71 Kent Strret Busselton WA 6280


PROJECT

COMMERCIAL DEVELOPMENT LOT 69 (HN23) Antlia Way Australind WA


| 1


HYDRAULIC SERVICES FLOOR PLAN WATER SUPPLY LAYOUT


SCALE	DESIGN	CHECKED			
1:100 @ A1	АВ	MM			
PROJECT #	DRAWING #	REVISION			
21.009	H04	В			
	This drawing is the property of HEMS Consulting Pty Ltd. Copyright © remains vested in HEMS Consulting Pty Ltd.				

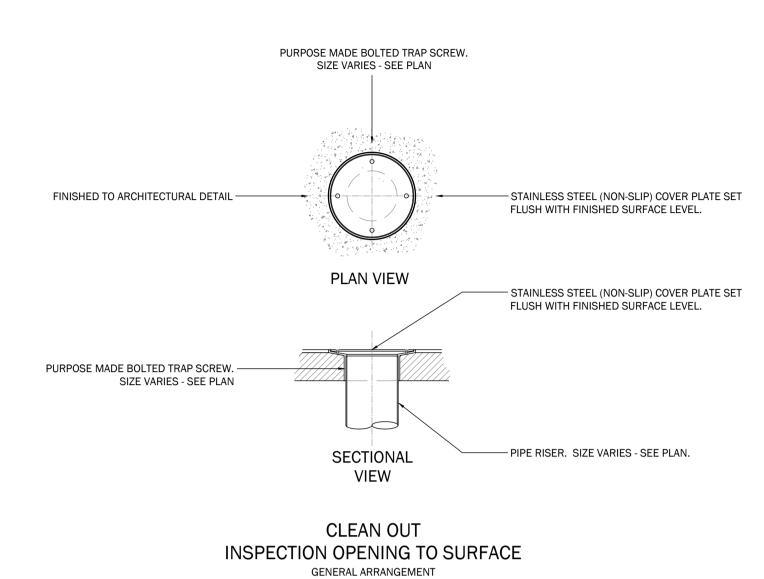

N.T.S.

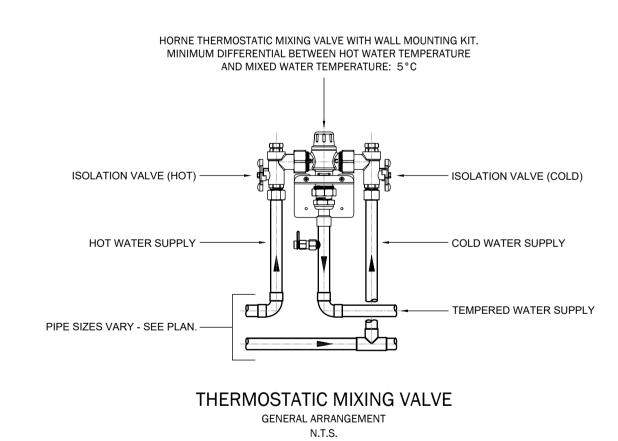

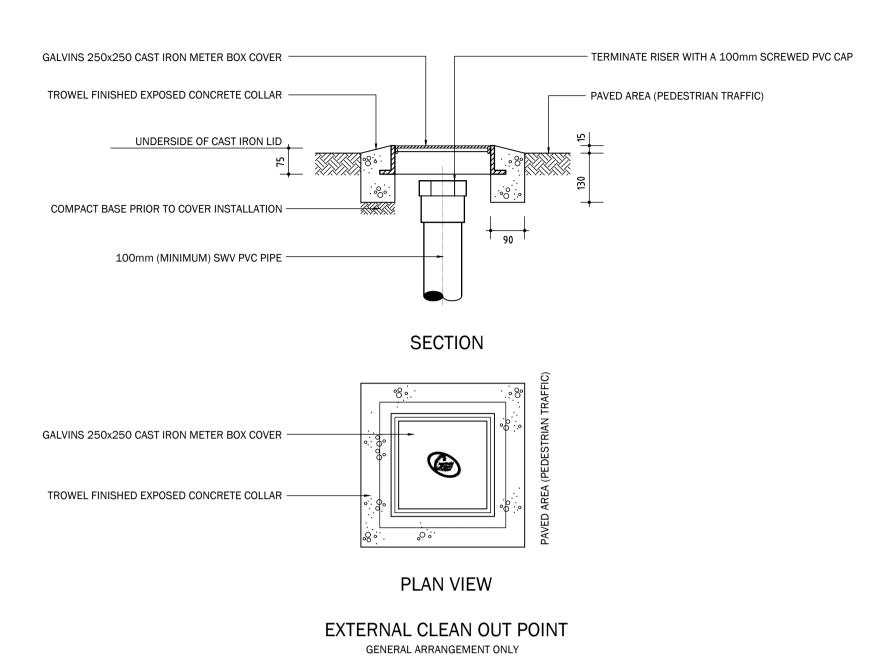

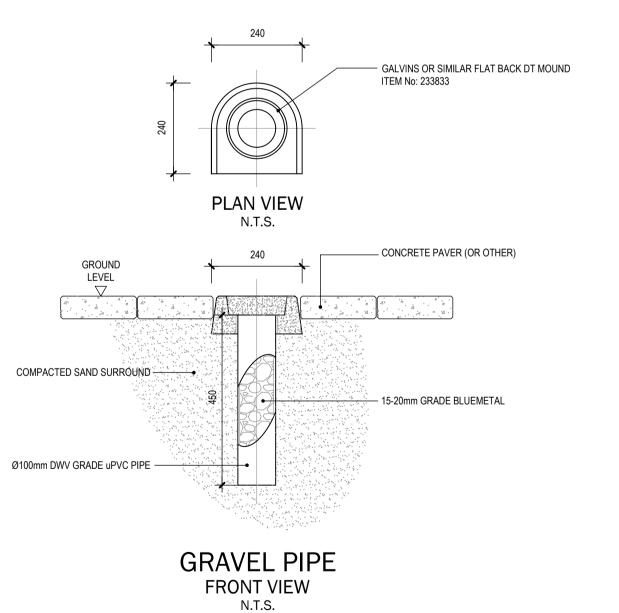

A 16.06.21 PRELIMINARY ISSUE AB
B 29.06.21 CDC ISSUE AB

The Hydraulic Services Sub-Contractor is to verify all dimensions on site before commencing work. Do not scale this drawing.

This drawing is to be read in conjunction with the contract specification in the interpretation of this drawing. The specification text has precedence over all of the illustrations on this drawing.

The following take precedence over the service requirements shown on this drawing and the contract specification:

• Legislative Federal, State and Local Authority Requirements.

Responsibilities and duties of the principal, contractor and the superintendent as defined in the Contract are not altered by this drawing.

| NOTES

Contractual Relationships

ISSUE DATE DESCRIPTION

CONSULTANT

www.hemsconsult.com.au

Hydraulic Electrical Mechanical Structural
E: info@hemsconsult.com.au
PO Box 381 Subiaco WA 6904

| ARCHITECT

D'AGOSTINO + LUFF ARCHITECTS

Unit 4 / 71 Kent Strret Busselton WA 6280

PROJECT

COMMERCIAL DEVELOPMENT LOT 69 (HN23) Antlia Way Australind WA

| TITLE

HYDRAULIC SERVICES STANDARD DETAILS SHEET 1 of 1

1:100 @ A1 AB MM

PROJECT # DRAWING # REVISION

21.009 H05 B

This drawing is the property of HEMS Consulting Pty Ltd. Copyright © remains vested in HEMS Consulting Pty Ltd.